

ЛЕГЕНДА:
LEGEND:




ВЕРТИКАЛЕН ВОДОПРОВОДЕН КЛОН
VERTICAL WATER-SUPPLY BRUNCH



ВЕРТИКАЛЕН КАНАЛИЗАЦИОНЕН КЛОН
VERTICAL SEWER BRUNCH



ВОДОСТОЧНА ТРЪБА – НОМЕР
RAIN SPOUT – NUMBER

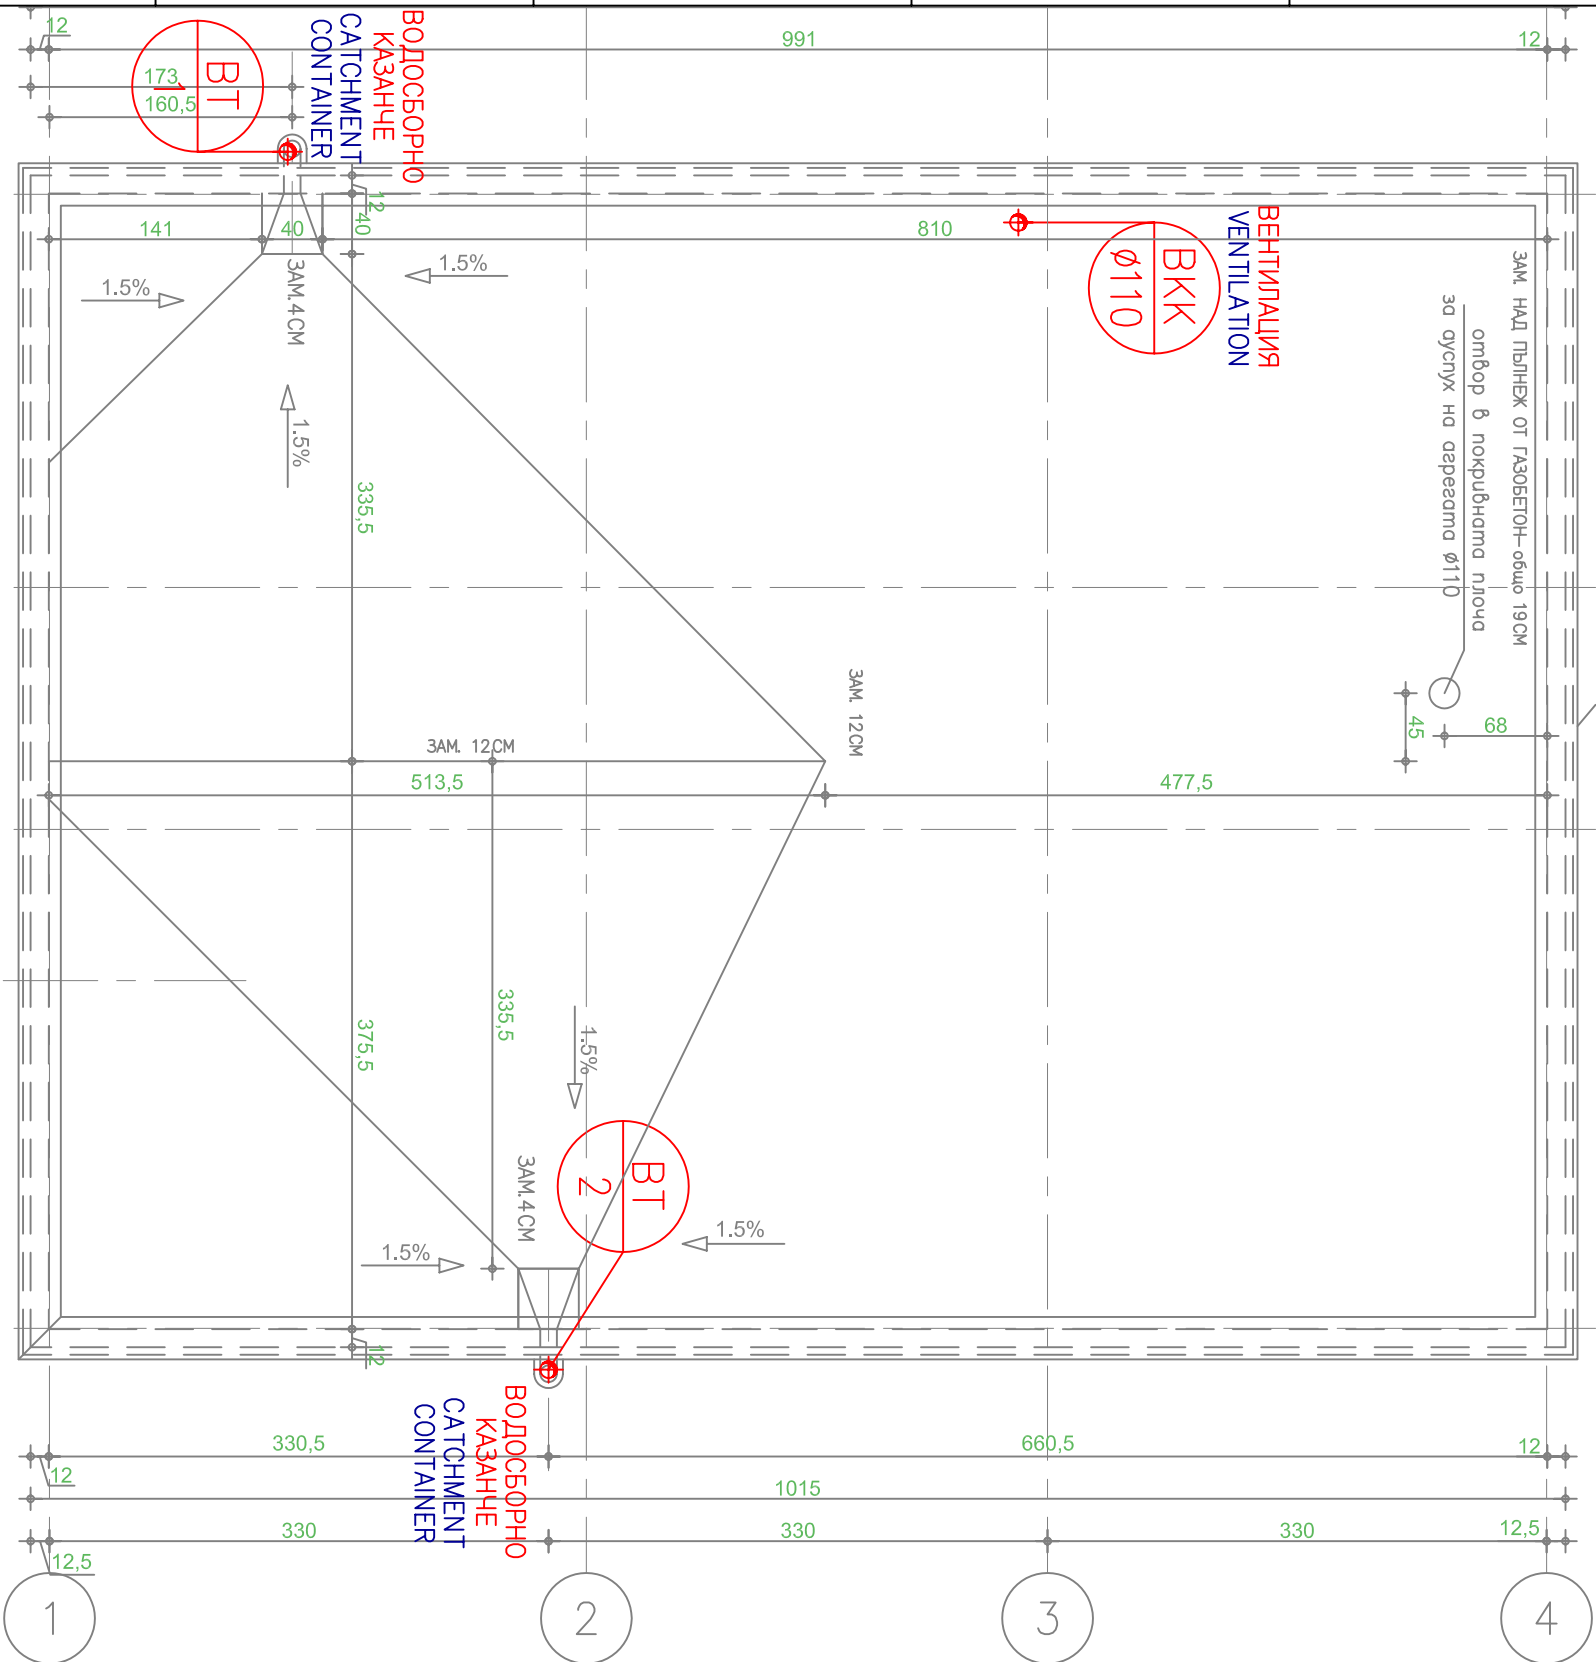

Rev. E			
Rev. D			
Rev. C			
Rev. B			
Rev. A	2008		
REVISION	DATE	NAME	APPROVED
MODIFICATION			
ALL RIGHTS RESERVED ! This drawing and the information contained therein is the property of Joint Venture. No part of this drawing may be reproduced, stored in a retrieval system, or transmitted in any form, or by any means, electronic, mechanical, photocopying, recording or otherwise, without the prior permission of the copyright holder.			

EMPLOYER

MINISTRY OF ENVIRONMENT AND WATER

Directorate "European Union Funds for Environment"

ISPA Measure No 2002/BG/16/P/PE/018

CONSULTANT -
JOINT VENTURE

DIWI Consult

International GmbH

LEADING PARTNER

PROJECT	SHOUMEN WATER CYCLE IMPROVEMENTS - BULGARIA				
	Lot No 1 : Network Design				
ОБЕКТ	ПОДОБРЕНИЕ НА ВОДНИЯ ЦИКЪЛ НА гр. ШУМЕН-БЪЛГАРИЯ				
	Лот № 1 Проект на мрежата				
PART	SEWAGE PUMP STATION				
ЧАСТ	КАНАЛИЗАЦИОННА ПОМПЕНА СТАНЦИЯ				
DRAWING TITLE	ROOF PLAN - WS&S ELEV. +4.00				
СЪДЪРЖАНИЕ	ПЛАН НА ПОКРИВ - ВИК КОТА +4.00				
TEAM LEADER ПРОВОДИТЕЛ ЕКИП	C. HAMILTON К. ХАМИЛТОН		COORDINATED СЪГЛАСУВАНИ		PHASE ФАЗА
TASK MANAGER ПРОЕКТ МЕНЕДЖЕР	R. KOTHE P. KOTE		ARCH. АРХ.	EL ЕЛ.	SCALE МАЩАБ
DESIGNER ПРОЕКТАНТ	eng.P.DOICHIKOV инж.П.ДОЙЧИНОВ		VP ВИ	HV ОВИ	DATE ДАТА
DESIGNER ПРОЕКТАНТ	eng.O.ZASHEV инж.О.ЗАШЕВ		CONSTR. КОНСТР.		REVISION РЕВИЗИЯ
					0
DRAWING No DD / SH / V / 02 / 004			ЧЕРТЕЖ No		